

ARCHITECT :

.....


JTC

 architects, inc.

65 NORTH FIRST AVE., SUITE 201
 ARCADIA, CA 91006

TEL | 626-254-8884 FAX | 626-574-7775
 E-MAIL : jtcarch@pacbell.net

JTC PROJECT NO: 26702.0C

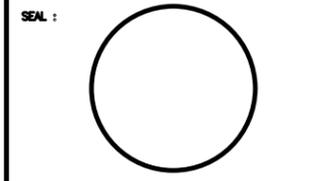

CONSULTANT :

PROJECT NAME :

YUCCA VALLEY BASE

ADDRESS :

**7230 PIONEERTOWN ROAD,
 YUCCA VALLEY, CA 92284**


The Gas Company
 A Sempra Energy Utility

8101 ROSEMEAD BLVD., SC720F
 PICO RIVERA, CA 90660-5100

NO.	DATE	DESCRIPTION	BY

SHEET NUMBER: **A-2**

SHEET COVER OF

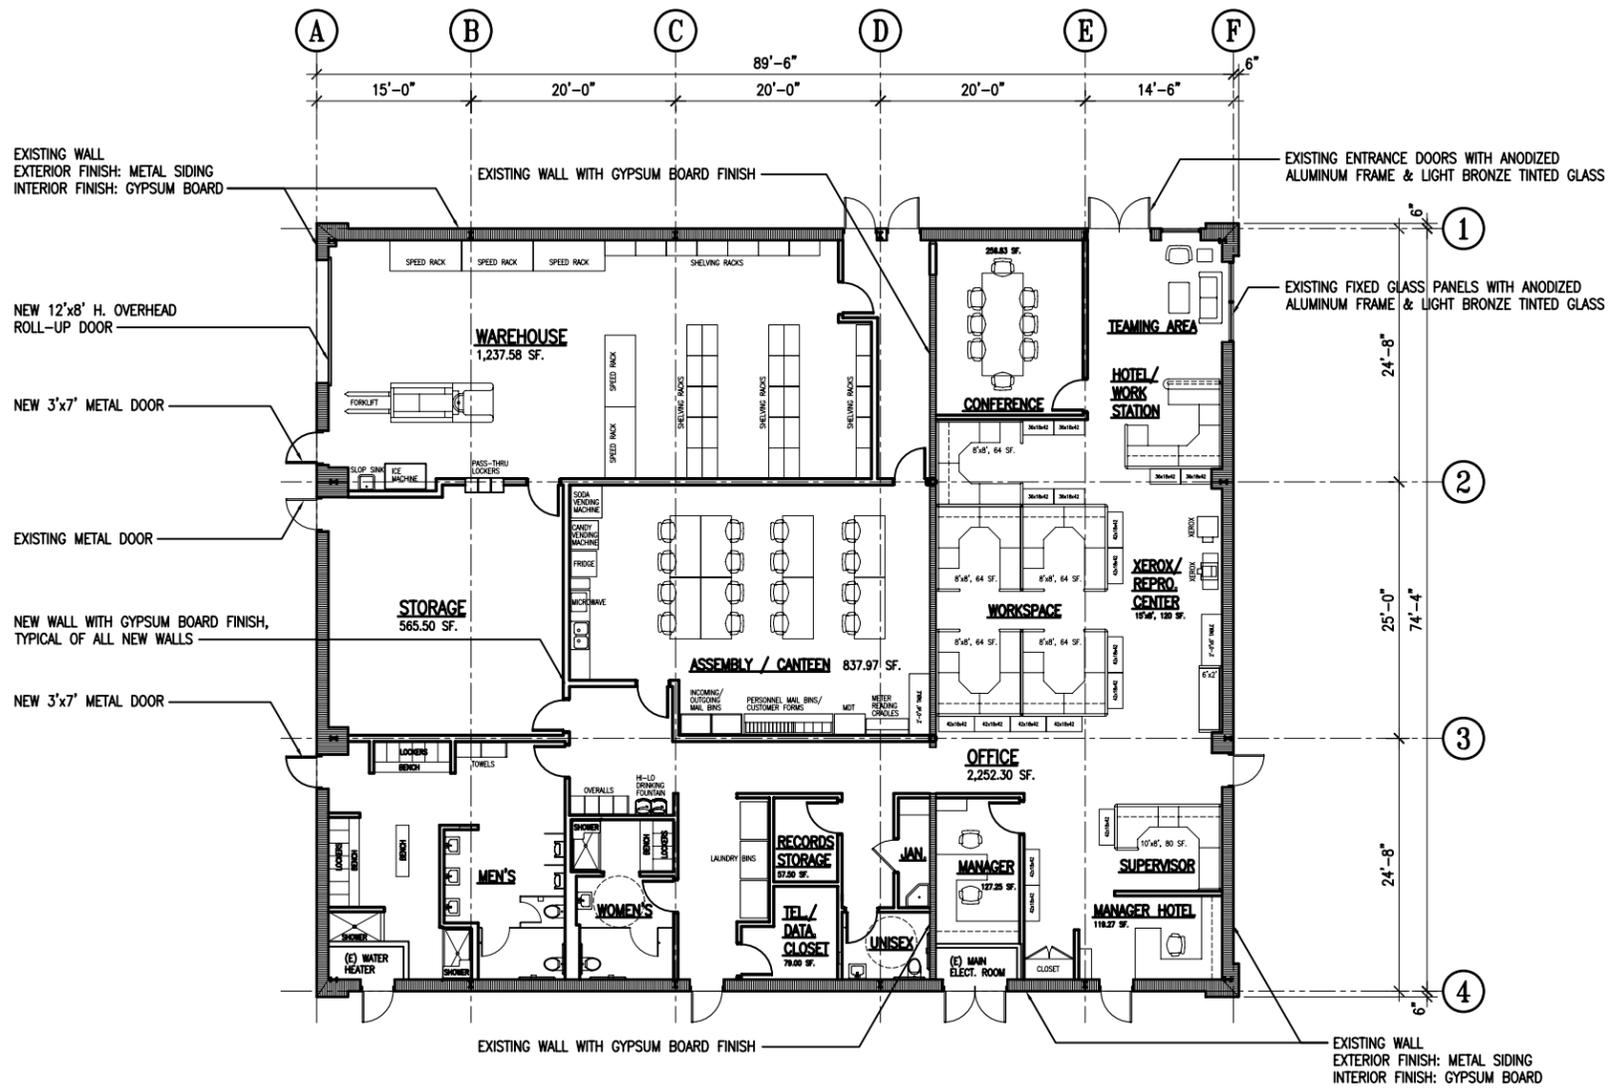

FLOOR PLAN

SCALE: 1/8"=1'-0"

1