



417.862.0558
417.862.3265
e-mail: architect@esterlyschelder.com

THOMAS A. LUNDBERG
ARCHITECT

1736 East Sunshine, Suite 417
Springfield, Missouri 65804

New O'Reilly Auto Parts Store
29 PALMS HIGHWAY
YUCCA VALLEY, CA

O'Reilly AUTO PARTS

O'Reilly
233 SOUTH PATTERSON
SPRINGFIELD, MISSOURI 65802
417-862-2674 PHONE

COMM # 0000

DATE: 00-00-00


REVISION DATE:

GENERAL NOTES:


- A. REFER TO PROJECT MANUAL FOR ADDITIONAL REQUIREMENTS.
- B. REFER TO PRE-ENGINEERED METAL BUILDING DRAWINGS FOR ADDITIONAL REQUIREMENTS.
- C. REFER TO MECHANICAL / ELECTRICAL PLAN FOR SYSTEM TYPES AND LOCATIONS.
- D. REFER TO SITE DEVELOPMENT PLANS FOR ADDITIONAL REQUIREMENTS.

KEY NOTES:

- 1 EXTERIOR PORTLAND CEMENT PLASTER (STUCCO): REFER TO EXTERIOR FINISH SCHEDULE.
- 2 MASONRY WALL CONSTRUCTION: REFER TO EXTERIOR FINISH SCHEDULE AND WALL SECTIONS.
- 3 PRE-FINISHED STANDING SEAM ROOF: BY PRE-ENGINEERED METAL BUILDING COMPANY.
- 4 PRE-FINISHED METAL CAP FLASHING: REFER TO EXTERIOR FINISH SCHEDULE.
- 5 NOT USED.
- 6 NOT USED.
- 7 CONCRETE MASONRY UNIT (CMU): SPLIT FACE HEAD AND JAMB UNITS.
- 8 LINE OF ROOF: DASHED LINE INDICATES LINE OF ROOF BEYOND WITH SLOPE OF 1/4" PER FOOT.
- 9 SIGN: APPROXIMATE OUTLINE OF SIGN. PROVIDE BLOCKING AS REQUIRED FOR MOUNTING OF SIGN. COORDINATE WITH SIGN COMPANY FOR EXACT SIGN PLACEMENT. OWNER FURNISHED AND INSTALLED LOGO. REFER TO SIGN PACKET INFORMATION FOR FURTHER DETAIL.
- 10 ADDRESS NUMBERS: 6" VINYL BY CONTRACTOR. COLOR TO BE WHITE.
- 11 NOT USED.
- 12 DOOR AND FRAME: (REFER TO DOOR SCHEDULE.)
- 13 STOREFRONT: (REFER TO FLOOR PLAN FOR WINDOW TYPES.)
- 14 LINE OF FOUNDATION: (REFER TO FOUNDATION PLAN.)
- 15 STEEL BOLLARDS: (9) TYPICAL AT STOREFRONT (2) AT O.H. DOOR LOCATION. FIELD PAINT PER EXTERIOR FINISH SCHEDULE. (REFER TO FOUNDATION PLAN.)
- 16 HOSE BIB: (REFER TO PLUMBING PLAN)
- 17 LIGHT FIXTURE: (REFER TO ELECTRICAL PLAN)
- 18 NOT USED
- 19 ROOF TOP UNIT: APPROXIMATE LOCATION (REFER TO MECHANICAL PLAN FOR EXACT LOCATION)
- 20 MECHANICAL WALL PENETRATIONS: PROVIDE FRAMING, FLASHING, AND SEALANT AS REQUIRED. (REFER TO M.E.P. SHEETS)
- 21 ROOF PIPING VENT: REFER TO DETAIL 5/A3.
- 22 CONCRETE SPLASH BLOCK: INSTALL AT EACH DOWNSPOUT.
- 23 MASONRY CONTROL / EXPANSION JOINT: (MATCH MASONRY) PROVIDE SEALANT OVER 1/2" DIAMETER FOAM BACKER ROD. REFER TO STRUCTURAL DRAWINGS.
- 24 STUCCO EXPANSION JOINT: REFER TO DETAIL 6/A3.
- 25 MANUFACTURED STONE VENEER (EL DORADO STONE): RUSTIC LEDGE "SAWTOOTH" INSTALL PER MANUFACTURERS RECOMMENDATIONS. REFER TO EXTERIOR FINISH SCHEDULE FOR MORE INFORMATION.
- 26 MANUFACTURED STONE VENEER SILL: EQUAL TO "SNAPPED EDGE WAINSCOT SILL" BY ELDORADO STONE. INSTALL PER MANUFACTURERS RECOMMENDATIONS. REFER TO EXTERIOR FINISH SCHEDULE FOR MORE INFORMATION.

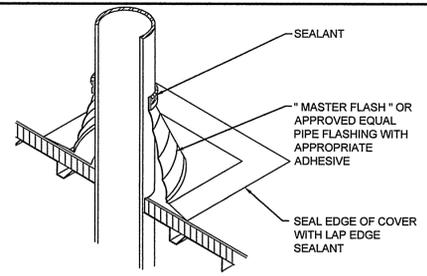

5 VENT PIPE
SCALE: N.T.S.

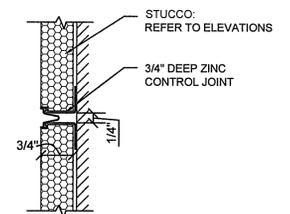


6 STUCCO JOINT DTL
SCALE: N.T.S.

EXTERIOR FINISH SCHEDULE


TYPE:	COMPANY TYPE:	COLOR:
STANDARD CONCRETE MASONRY UNIT (C.M.U.) SMOOTH FACE (8" X 8" X 16" NOM.) *PROVIDE FULL 8" FACE AT ALL CORNERS COURSE: RUNNING	PER LOCAL SUPPLIER	SHERWIN WILLIAMS PAINT (1) COAT S-W PREPRITE BLOCK FILLER B25W25 (NO LESS THAN 8 MILS) (2) COATS S-W CONFLX XL SMOOTH ELASTOMERIC A5-400 (NO LESS THAN 5.7 MILS EACH COAT) COLD WEATHER APPLICATIONS: SHERWIN WILLIAMS PAINT (1) COAT S-W LOXON BLOCK SURFACER (NO LESS THAN 8 MILS) (2) COATS S-W ULTRACRETE SOLVENT BORNE SMOOTH B48 (NO LESS THAN 8 MILS EACH COAT OR 16 MILS TOTAL) COLOR: FIELD PAINT - COLOR TO MATCH STONE ABOVE SEE SPECIFICATIONS SECTION 09900
MANUFACTURED STONE VENEER	ELDORADO STONE CO.	RUSTIC LEDGE "SAWTOOTH"
EXTERIOR PORTLAND CEMENT PLASTER (STUCCO) (SEE SPEC)	PER LOCAL SUPPLIER	NOTE: COLOR TO BE INTEGRAL IN THE TOP COAT OF PLASTER AND IS TO MATCH COLOR INDICATED BY SHADING SHERWIN WILLIAMS "SOFTER TAN" SW6141 TEXTURE: SANDBLAST SHERWIN WILLIAMS "LATTE" SW6108 TEXTURE: SANDBLAST MATCH DRYVIT COLOR 346 "PATCHWOOD"
STOREFRONT (NO SUBSTITUTES)	KAWNEER	CLASSIC BRONZE
BOLLARDS	IN FIELD	FIELD PAINT BRONZE TO MATCH STOREFRONT COLOR
EXTERIOR DOORS	OWNER	FACTORY PRIMED FIELD PAINT SHERWIN WILLIAMS "LATTE" SW6108
OVERHEAD DOOR	OWNER	FACTORY PRIMED FIELD PAINT SHERWIN WILLIAMS "LATTE" SW6108
FACTORY PRIMED SHEET METAL CAP FLASHING	BY METAL BUILDING MFG'R	FIELD PAINT SHERWIN WILLIAMS "SOFTER TAN" SW6141

DIMENSIONS TO BE EQUAL TO ALLOW SIGN TO BE CENTERED ABOVE PORTAL

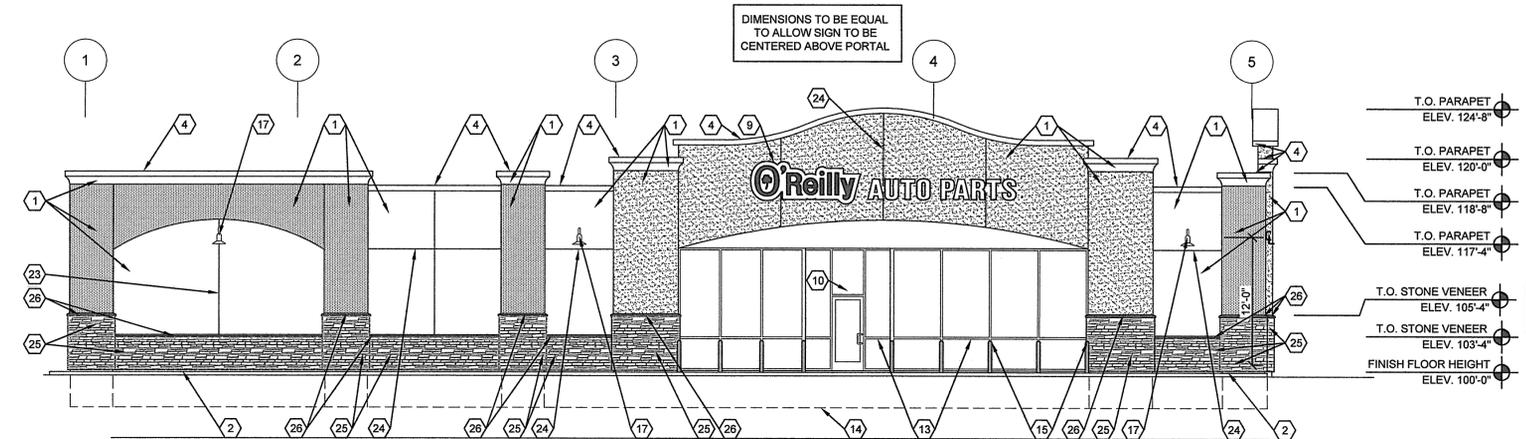


1 SOUTH ELEVATION
SCALE: 1/8" = 1'-0"

49' O'REILLY AND 24' AUTO PARTS (LINEAR)

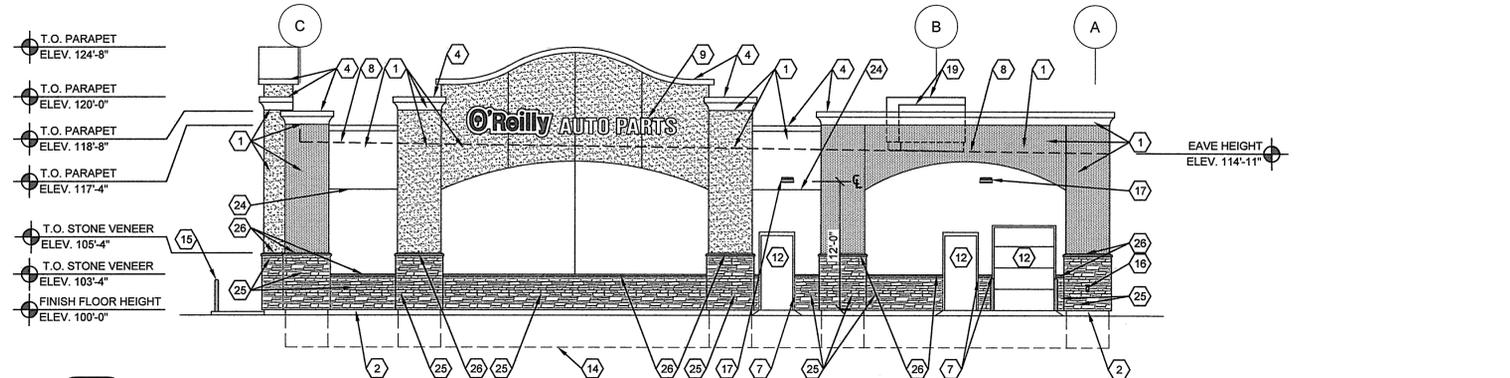


2 EAST ELEVATION
SCALE: 1/8" = 1'-0"

36' O'REILLY AND 19' AUTO PARTS (LINEAR)

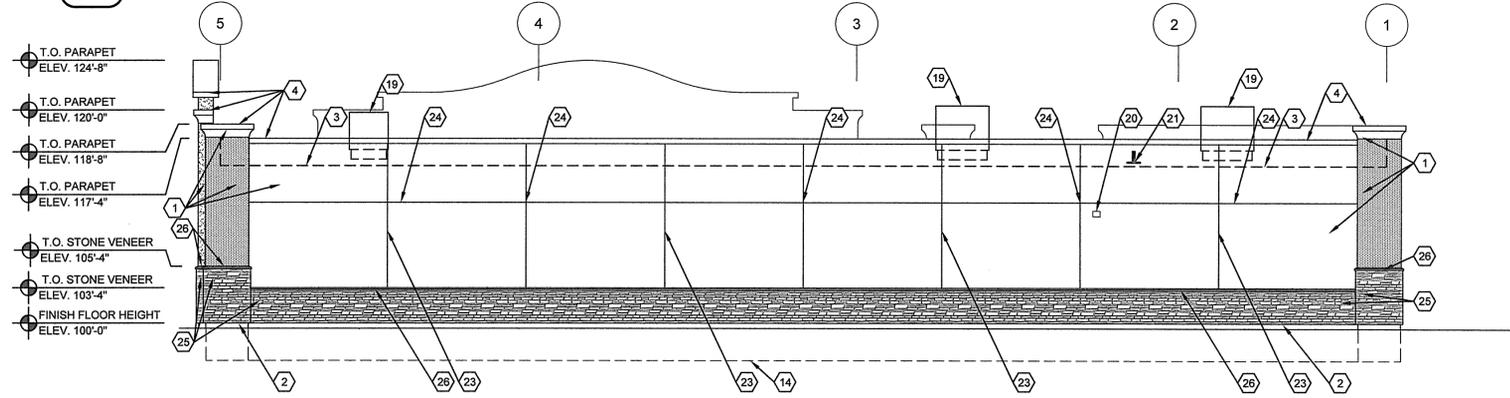

3 NORTH ELEVATION
SCALE: 1/8" = 1'-0"

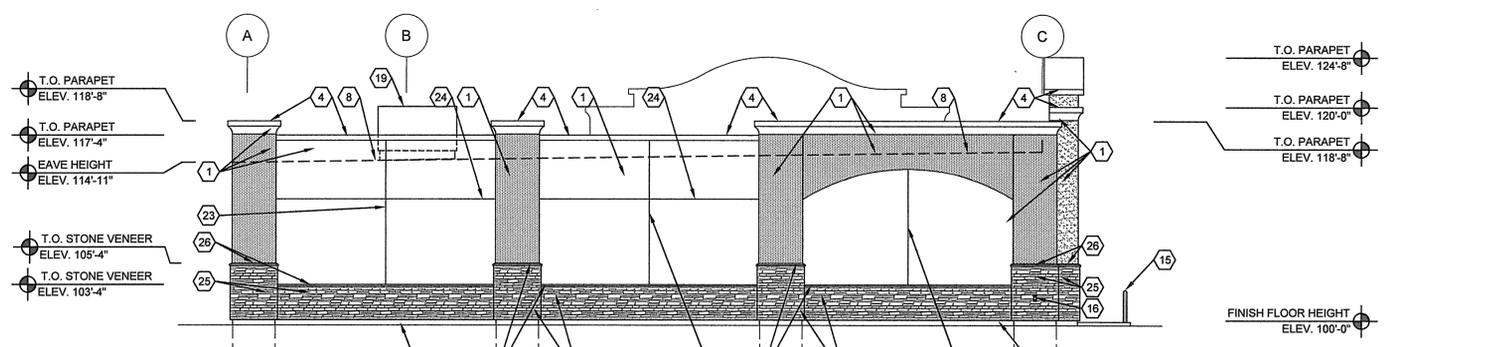

4 WEST ELEVATION
SCALE: 1/8" = 1'-0"